




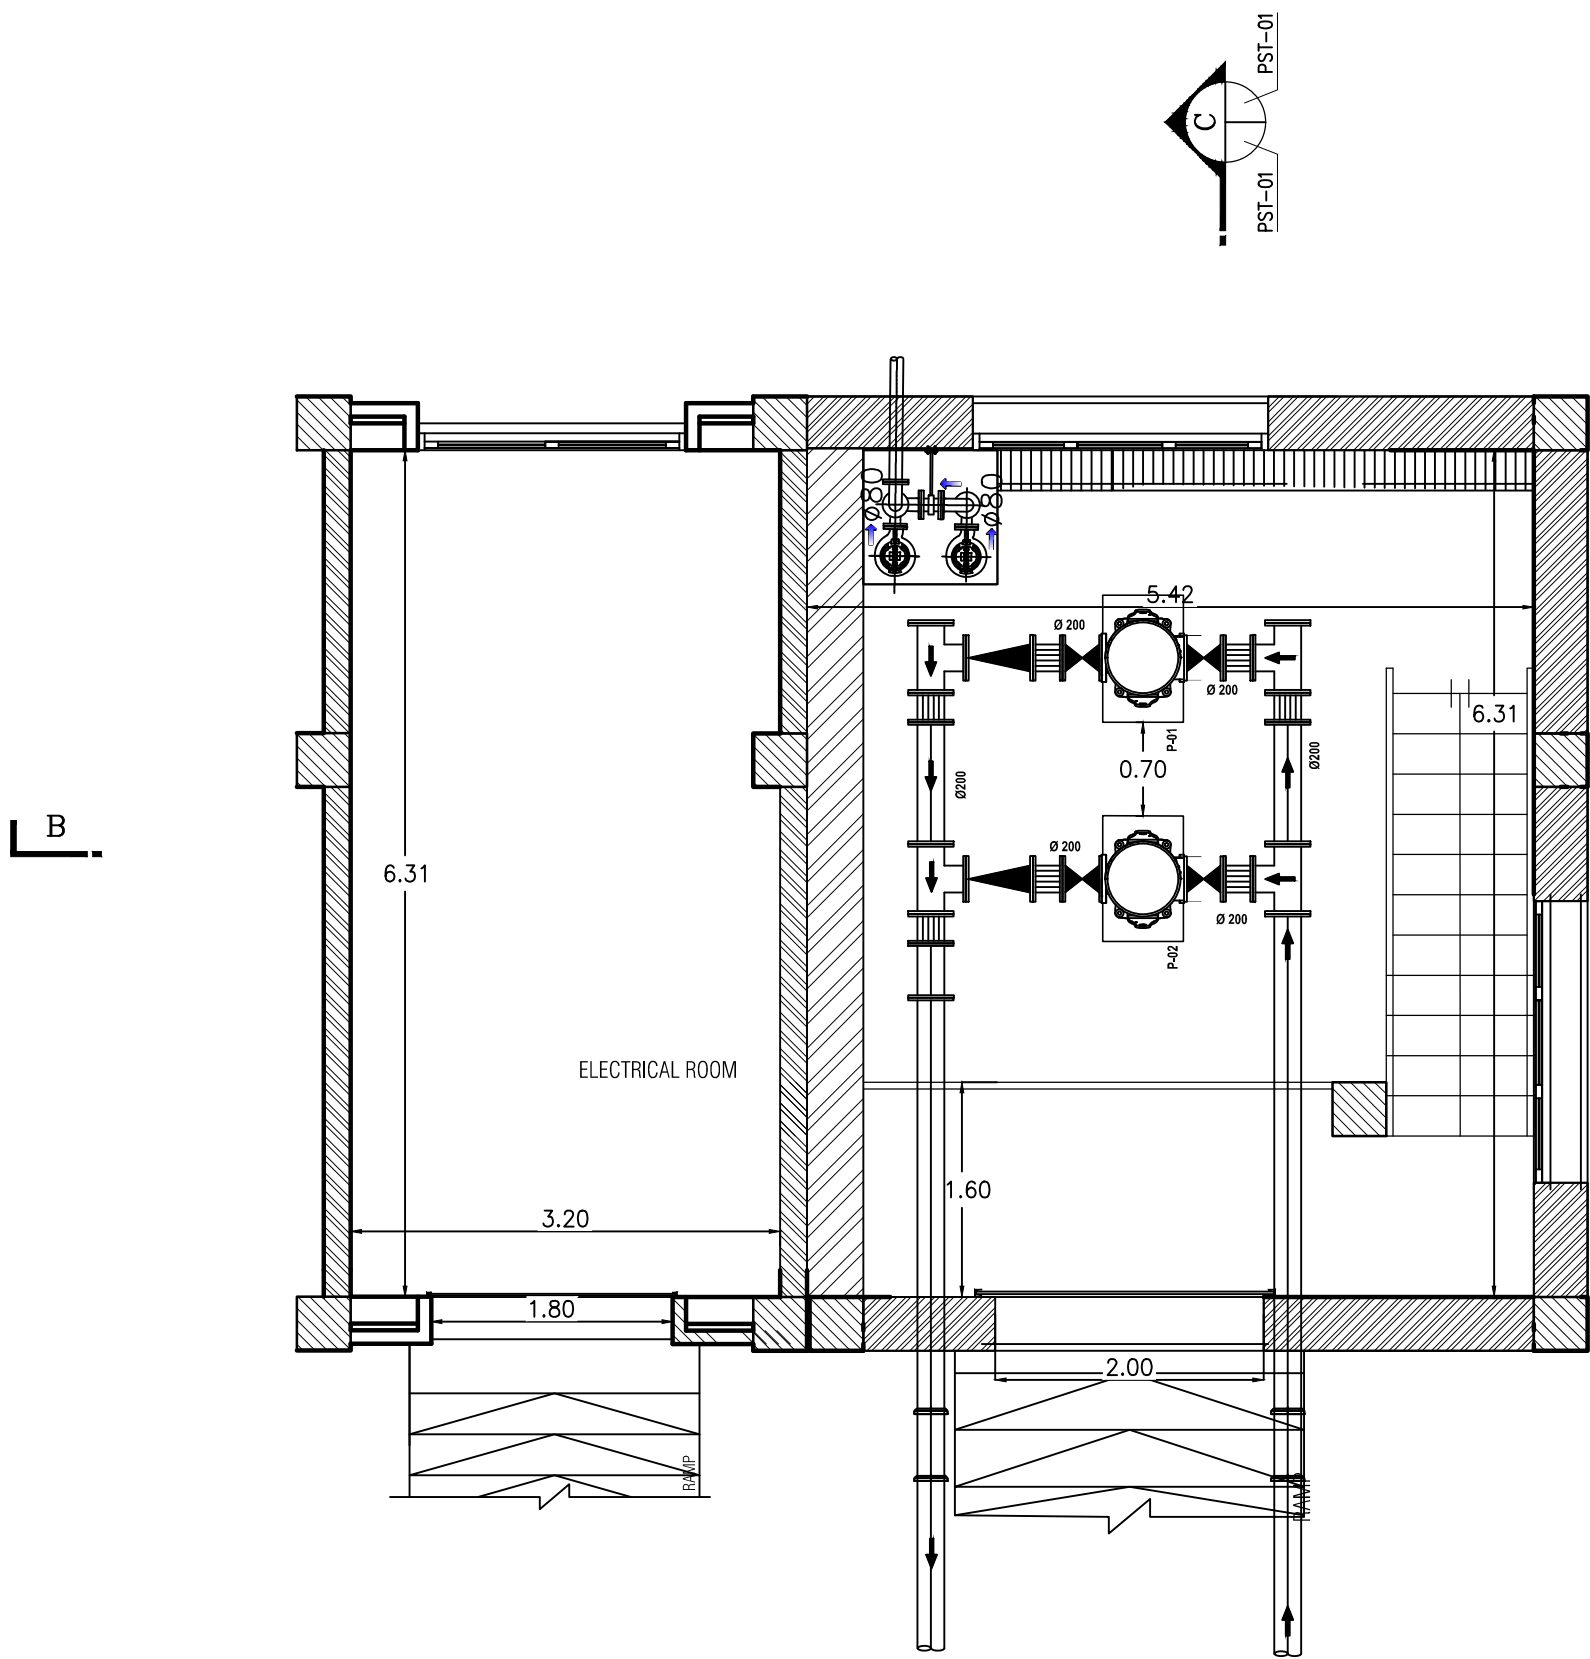

2 PLAN

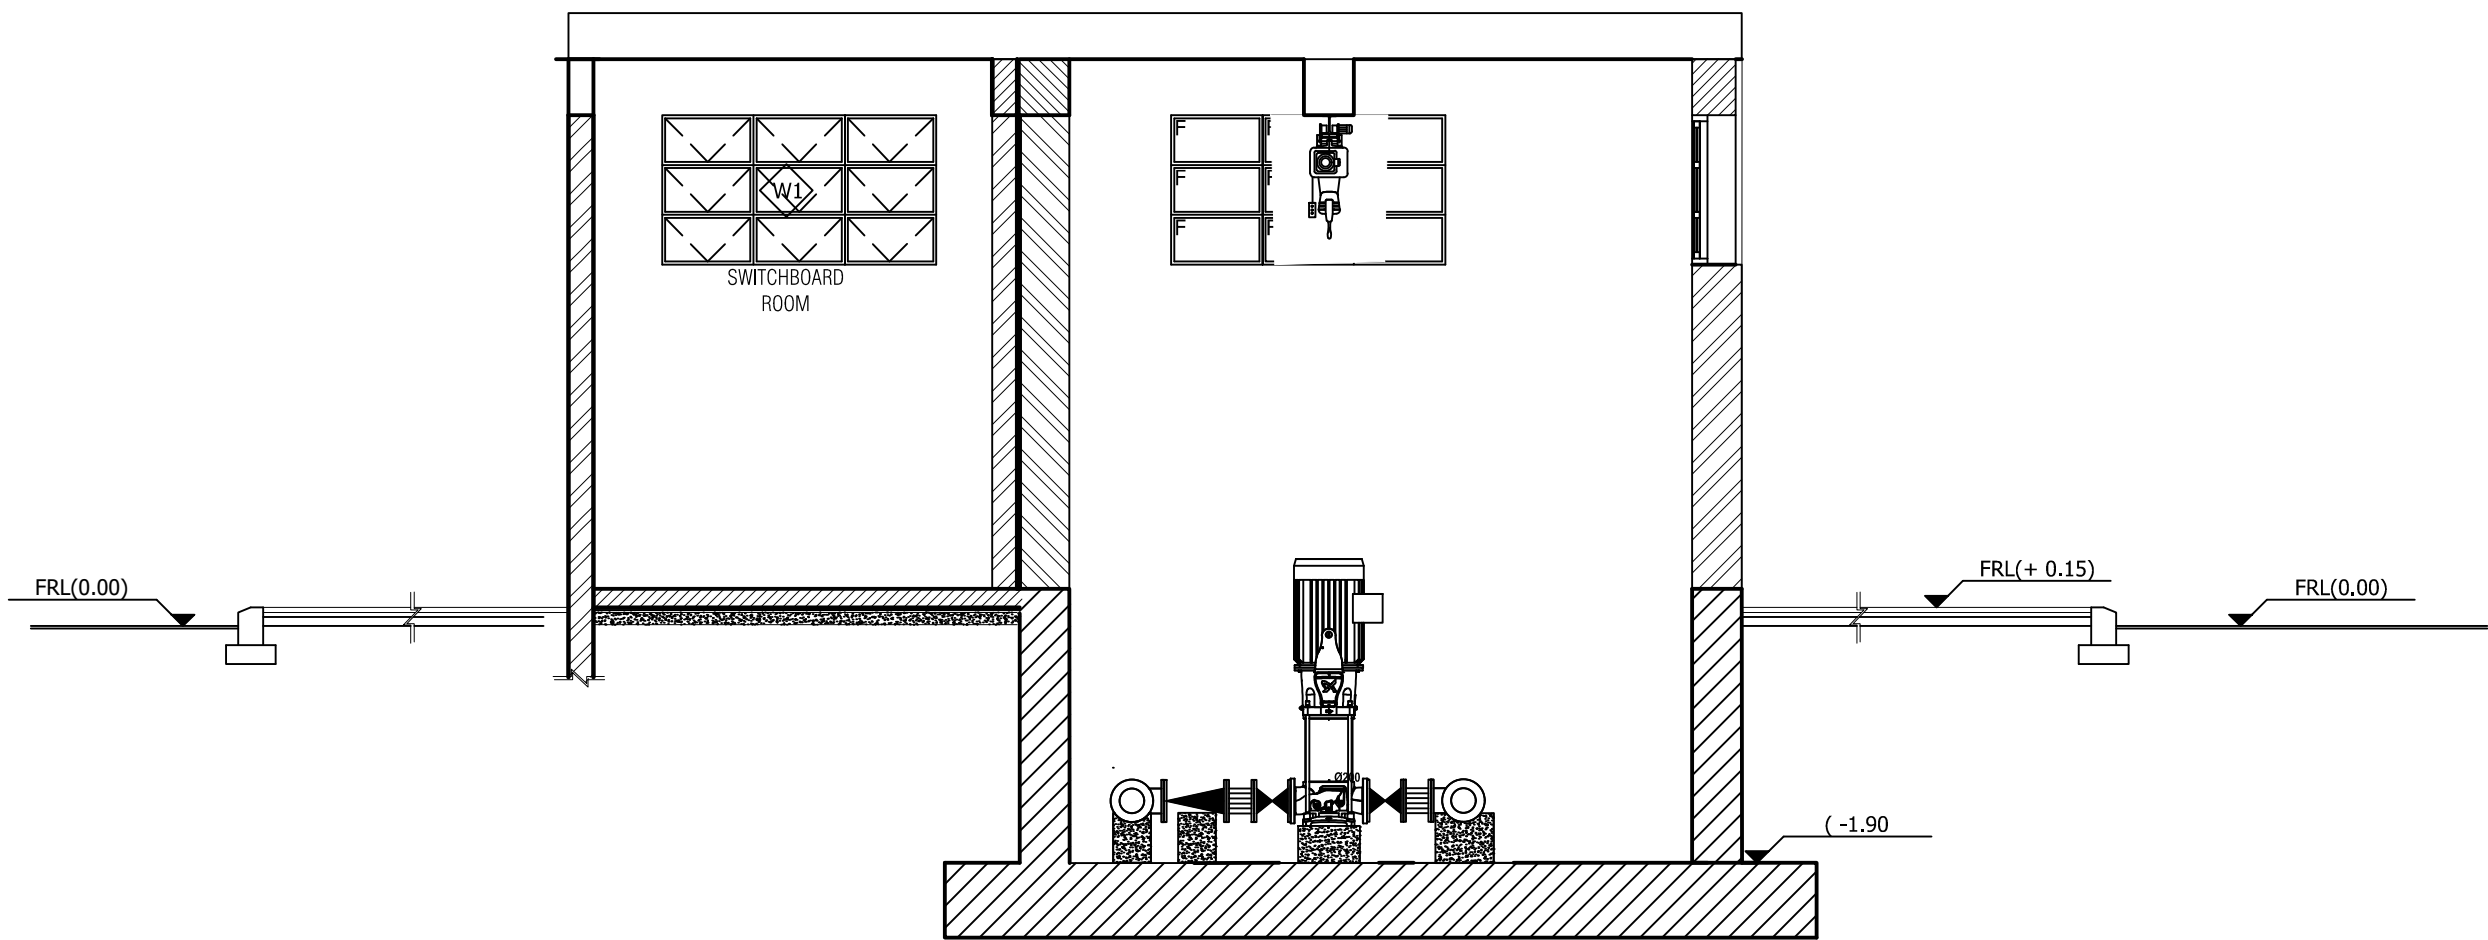

2 SECTION (B)

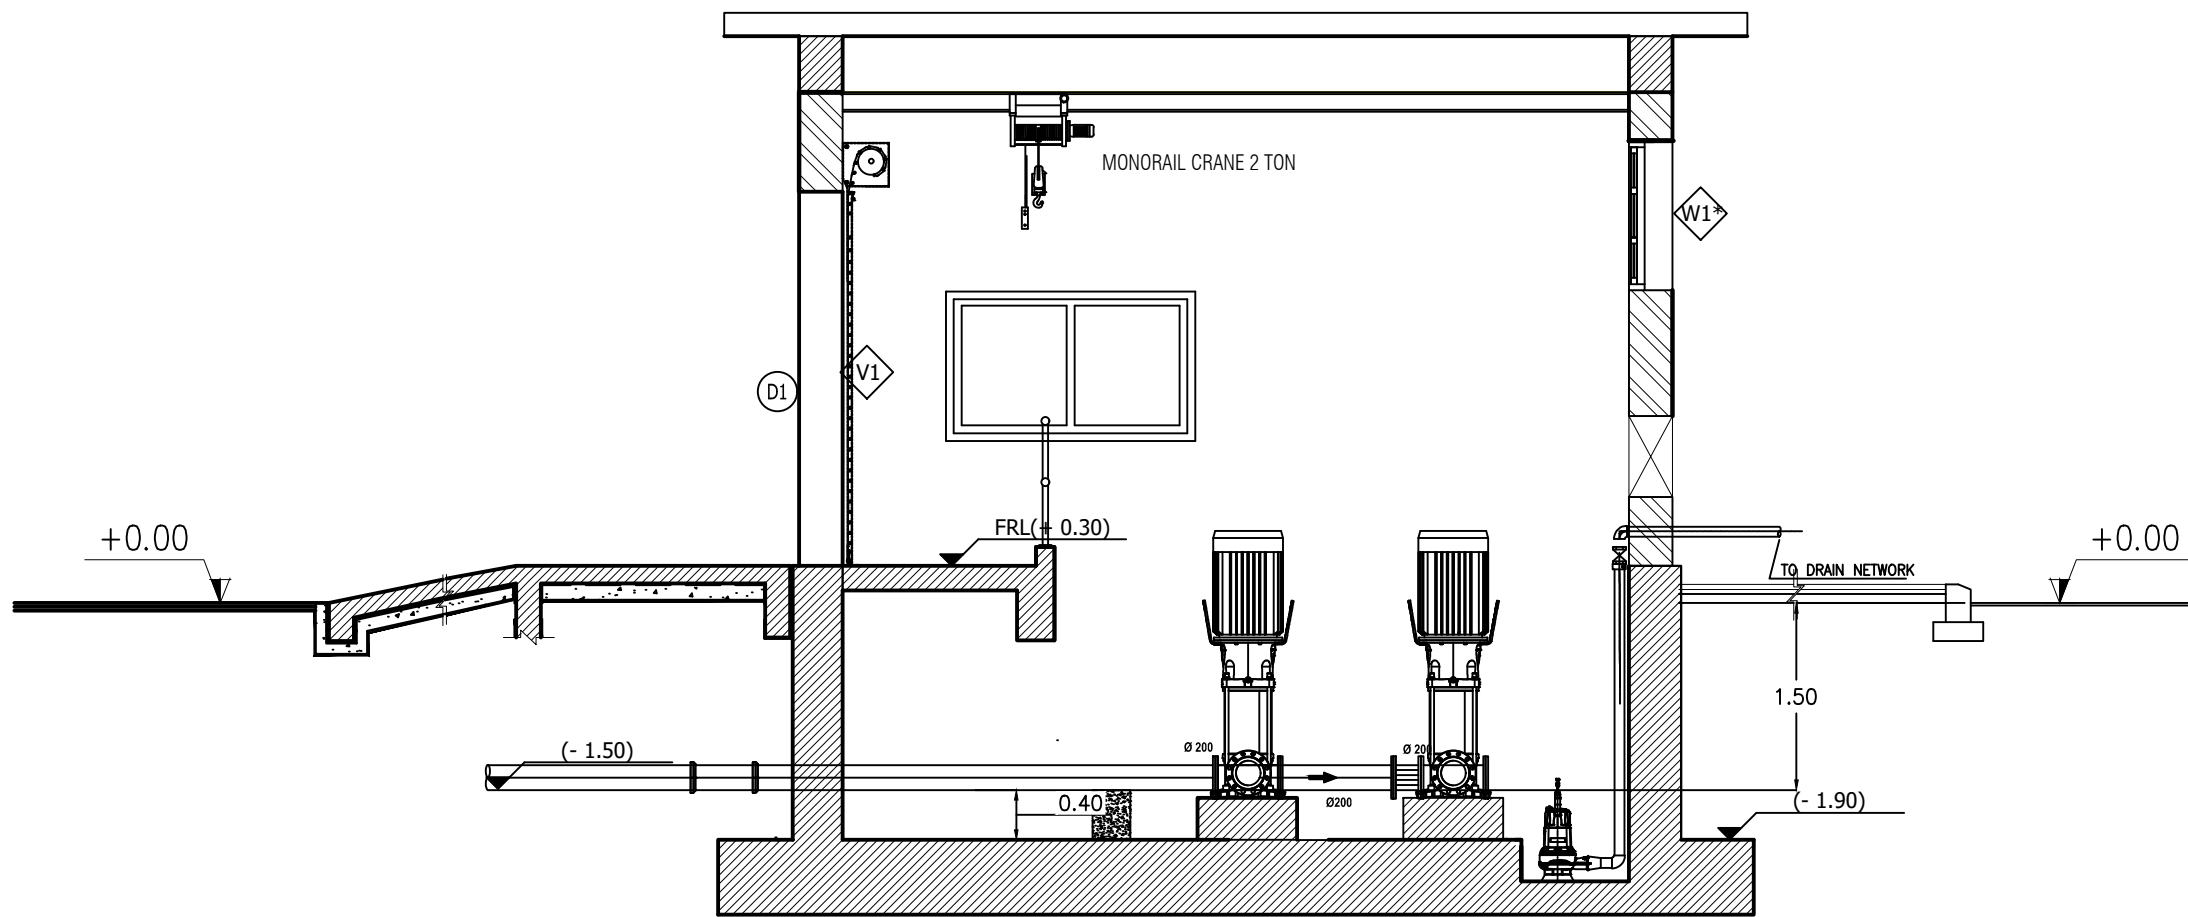

2 SECTION (C)

1. FOR ALL EXCAVATION WORKS AND LAYING OF PIPES, CABLES ETC.:
GROUND MUST BE EXPLORED CAREFULLY BEFOREHAND AND EXCAVATION MUST PROCEED WITH ABSOLUTE CAUTION. EXPLORING AND SOUNDING OF EXISTING STRUCTURES AND PIPES AND CABLES IS ESSENTIAL.
2. FINAL LOCATIONS AND DIMENSIONS OF RECESSES AND OPENINGS TO BE CONFIRMED BY CORRESPONDING SUPPLIERS (E.G. ELECTRICAL, HVAC, AUXILIARY UTILITIES).
3. SEPARATE SHOP DRAWINGS TO BE PROVIDED FOR ACCESS LADDERS, HANDRAILS, PLATFORMS, GRATINGS, STAIRS AND LADDER.
4. FINAL DIMENSION IS SUBJECT TO DETAIL DESIGN OF PIPE SUPPORT.
5. ALL DIMENSION IN MILLIMETERS.
6. FINAL LEVELS AFTER SITE SERVAY DATA RECEIVED.
7. FINAL PIPE DIAMETER AFTER HYDRAULIC STUDY APPROVAL.
8. CONCRETE DIMENSIONS WILL BE IN STRUCTURE DRAWINGS .

SYMBOL	DESCRIPTION
	GATE VALVE - SLUICE VALVE
	NON RETURN VALVE
	DISMANTLING PIECE
	TEE CONECTION
	FLEXIBLE JOINT
	FLOWMETER
	BEND 90
	REDUCER
	FLANGED AND SPIGOT PIPE

DATE	REV.	DESCRIPTION	BY	CHKD.	APPRD.
30-09-2026	00	REVIEW AND APPROVAL	S.H	M.A	M.H

CLIENT:	الشركة العامة للمياه والصرف الصحي ب.ب: 1047، ر.ب: 113 مركز الاتصال: 1442
Oman Water and Wastewater Services Company	شركة المياه والصرف الصحي ب.ب: 1047، ر.ب: 113 مركز الاتصال: 1442

MAIN CONSULTANT:	إستشاري الإنشاءات ابن خلدون و المدائن للاستشارات الهندسية بالتعاون مع انجيكون P.O. Box: 2187, P.C. 112 Muscat, Sultanate of Oman Tel: 24506080, Fax: 24591880
ابن خلدون و المدائن للاستشارات الهندسية بالتعاون مع انجيكون	شركة المياه والصرف الصحي ب.ب: 1047، ر.ب: 113 مركز الاتصال: 1442

CONTRACTOR:	شركة تاركت ش.م.م. ص.ب: 574، ر.ب: 112 Postal Code-112 Sultanate of Oman Tel: 24505970, Fax: 24505982 E-mail: target@target-llc.com
TARGET L.L.C	شركة تاركت ش.م.م. ص.ب: 574، ر.ب: 112 Postal Code-112 Sultanate of Oman Tel: 24505970, Fax: 24505982 E-mail: target@target-llc.com

SUB CONTRACTOR:	AAW & PARTNERS LLC Consulting Engineers Post Box No. 2059, Ruwi, Postal Code 112 Sultanate of Oman www.aaw.com.eg
AAW & PARTNERS LLC	شركة تاركت ش.م.م. ص.ب: 574، ر.ب: 112 Postal Code-112 Sultanate of Oman Tel: 24505970, Fax: 24505982 E-mail: target@target-llc.com

PROJECT	DESIGN AND CONSTRUCT OF TE CONNECTION FOR MEDICAL CITY FOR MILITARY AND SECURITY SERVICES PROJECT PACKAGE B7D(ANSAB) (Ten. No. T/2460881/2023)
AREA	B7D-ANSAB
DRAWING TYPE	TE PIPELINE PROFILE
DRAWING TITLE	PUMP STATION FLOOR PLAN & SECTION A-A,B-B

DRAWN BY: M.H	CHECKED BY: M.A	APPROVED BY: M.H
CONTRACT NO. OWWSC/T/2460881/2023	DATE : 30-09-2026	SCALE:N.T.S
DRWG NO:	BR 07-D	GEN STR 002 00